
## ANNEX 1

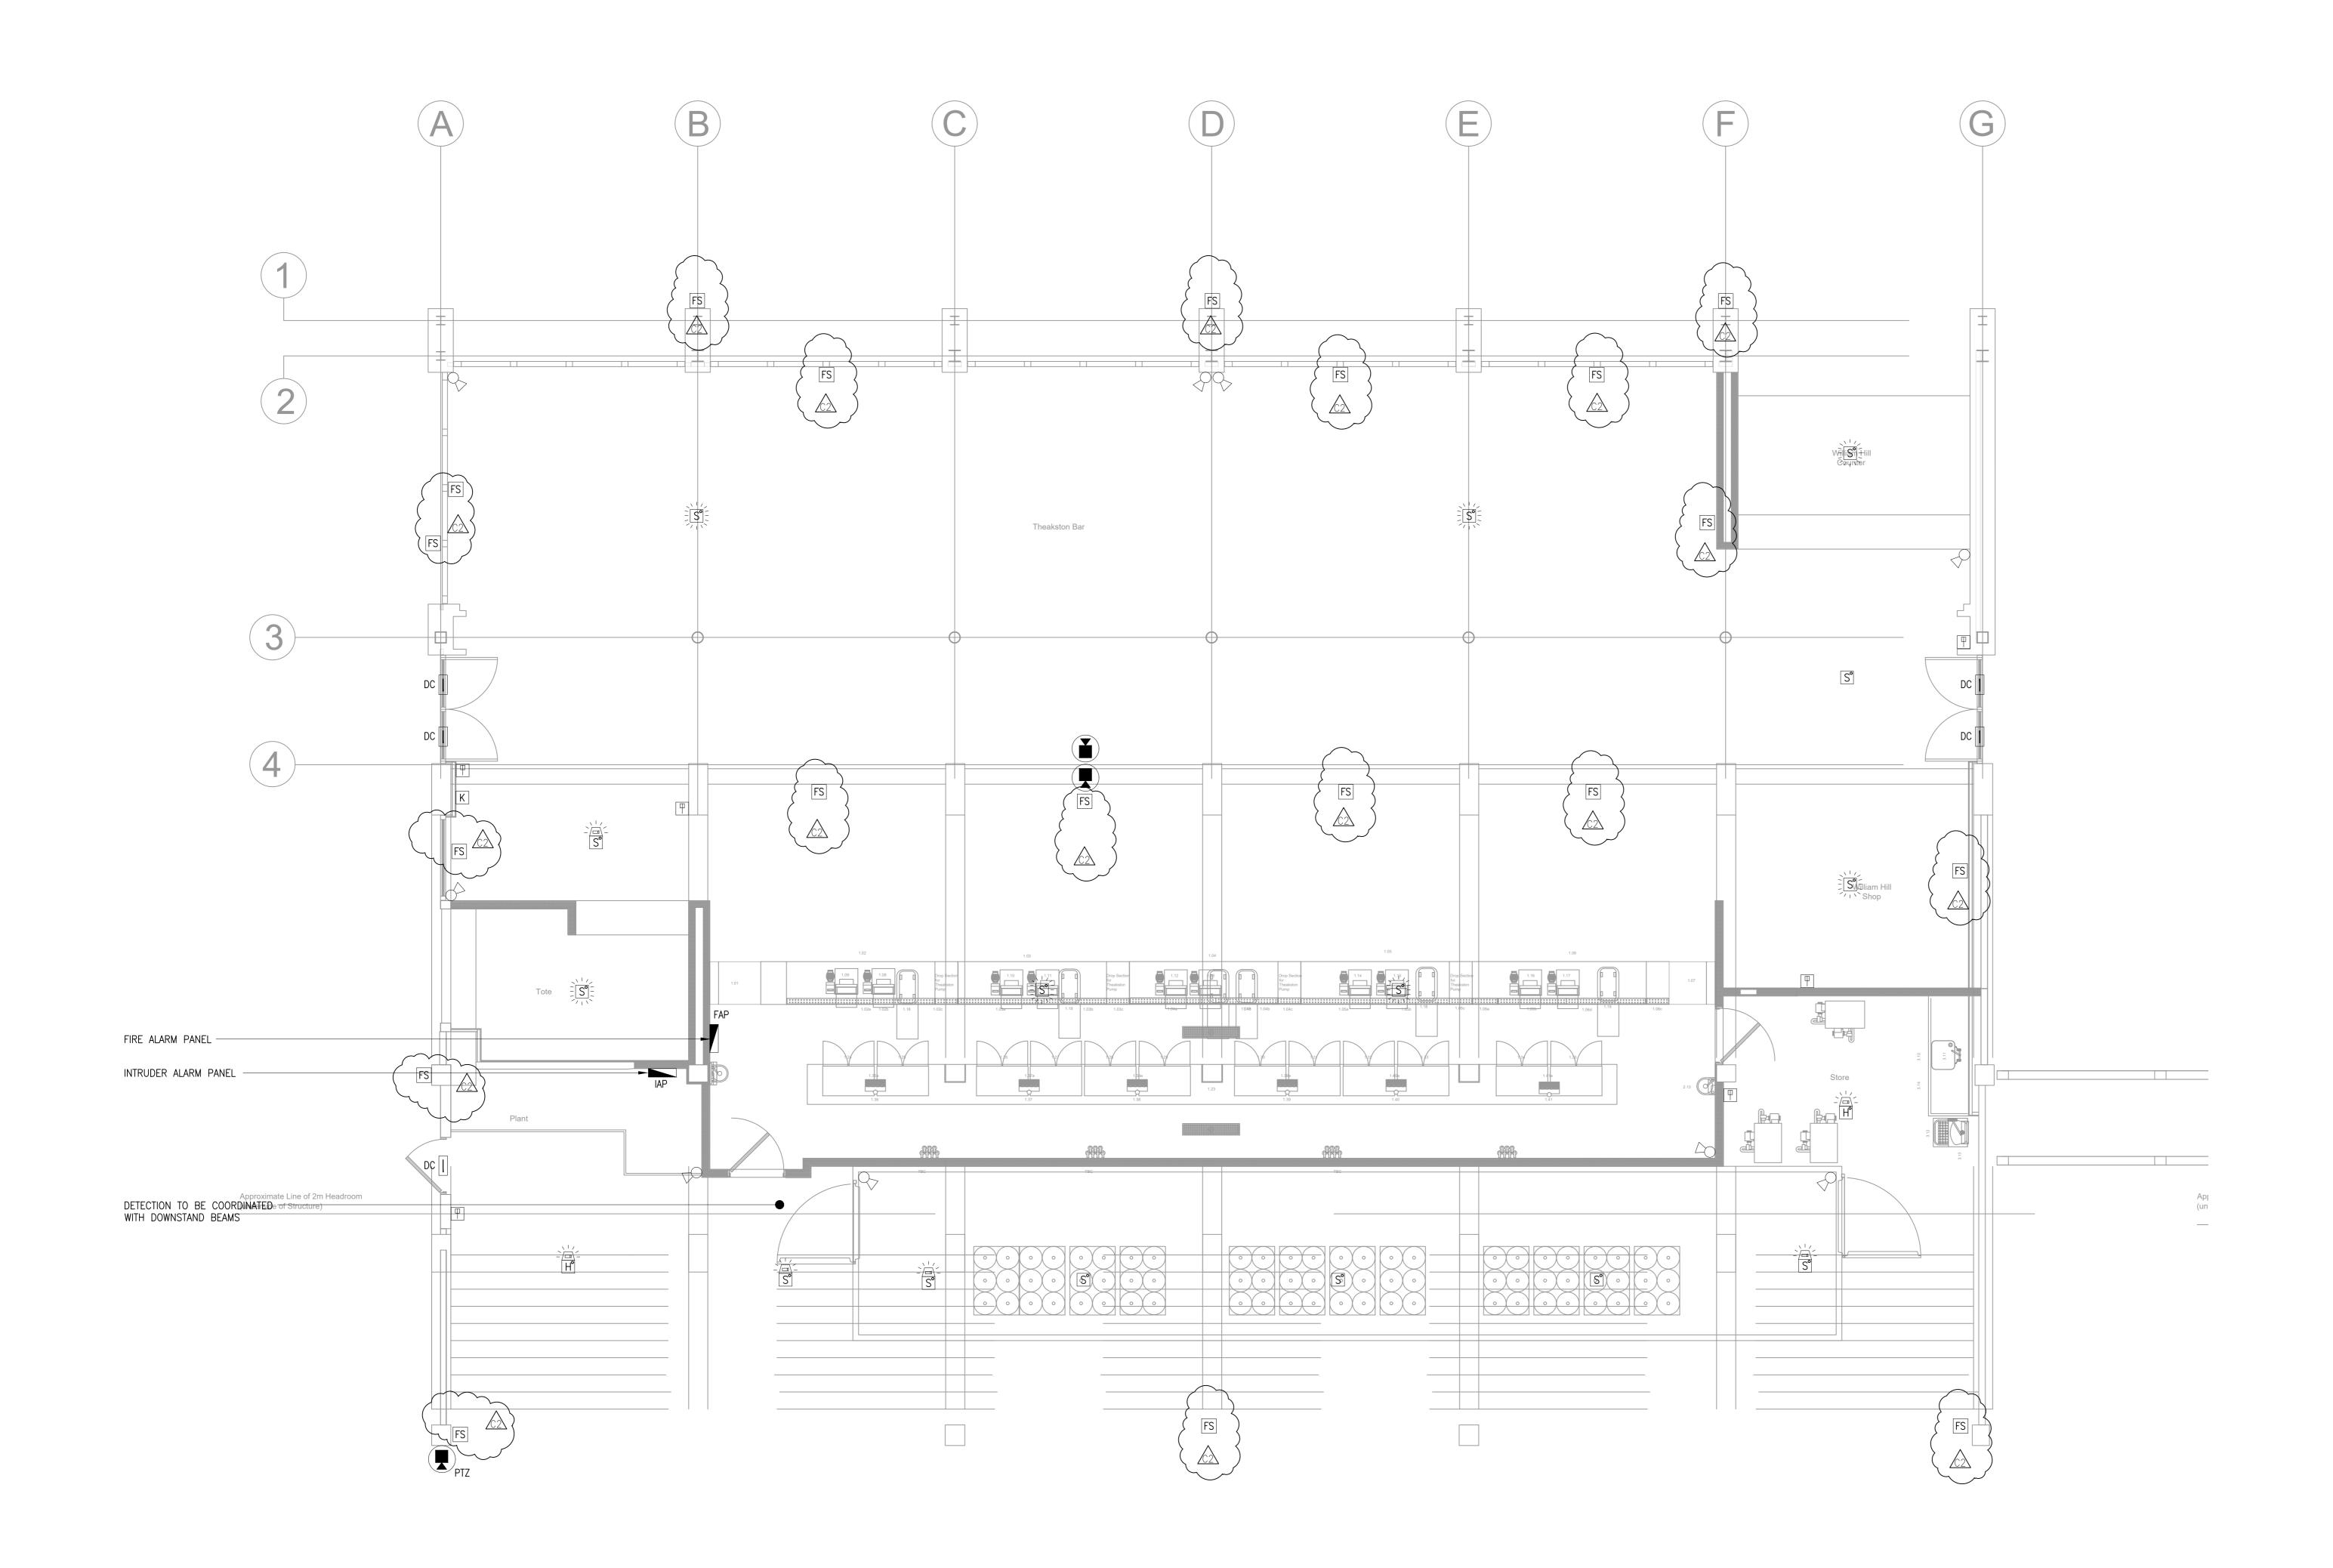

HORIZON BUILDING SERVICES CONSULTANTS LTD THIS DRAWING IS CONFIDENTIAL AND MAY NOT BE USED, COPIED OR DISCLOSED TO ANYONE WITHOUT PERMISSION OF HORIZON BUILDING SERVICES CONSULTANTS LTD DO NOT SCALE FROM THIS DRAWING

NOTES:

THE DRAWINGS ARE TO BE READ IN CONJUNCTION WITH ALL OTHER ACCOMPANYING FHP DRAWINGS, SCHEDULES & SPECIFICATION DOCUMENTS

ALL DIMENSIONS IN MILLIMETRES UNLESS OTHERWISE

3. THE DRAWINGS ARE NOT TO BE SCALED FROM.

ALL ROUTES ARE TO BE CHECKED ON SITE PRIOR TO THE COMMENCEMENT OF WORKS.

5. ALL PIPEWORK, DUCTWORK, CONTAINMENT & PLANT TO BE INSTALLED IN ACCORDANCE WITH THE MANUFACTURER'S RECOMMENDATIONS AND GUIDELINES

ALL SERVICES ROUTES ARE TO BE AGREED BETWEEN THE DESIGN TEAM AND CLIENT PRIOR TO INSTALLATION AND TO BE CHECKED ON SITE PRIOR TO THE COMMENCEMENT OF WORKS.

<u>LEGEND</u> FIRE ALARM

FIRE ALARM CONTROL PANEL

IU FIRE ALARM INTERFACE UNIT

MANUAL CALL POINT

WALL MOUNTED SOUNDER BEACON

S SMOKE DETECTOR

SMOKE DETECTOR WITHIN CEILING

VOID

SMOKE DETECTOR WITHIN ROOF

SMOKE DETECTOR WITH

SMOKE DETECTOR WITH SOUNDER BASE

SOUNDER BASE/BEACON

SMOKE DETECTOR WITH FLASHING BEACON HEAT DETECTOR WITH SOUNDER

BASE/BEACON HEAT DETECTOR WITH FLASHING BEACON

★ CEILING MOUNTED FLASHING BEACON

PTZ DOME CCTV CAMERA



INTRUDER ALARM PANEL

DOOR CONTACT

PIR DETECTOR

DUAL TECH DETECTOR

A EXTERNAL SOUNDER

K KEYPAD

DISABLED WC ALARM

REPEAT LAMP UNIT — WALL MOUNTED

D\_E DISABLED ALARM PULL SWITCH OR DISABLED ALARM RESET BUTTON

VOICE ANNUNCIATION (FIRE)

(FS) CEILING MOUNTED RECESSED FIRE DOME SPEAKER

FS WALL MOUNTED RECESSED FIRE DOME SPEAKER

C2 SPEAKERS ADDED TO SPECIALIST REQUIREMENTS C1 CONTRACT ISSUE

CONTRACT





12.01.24 PT



email. engineers@horizon.uk.net tel. 01904 672223 web. www.horizon.uk.net Horizon Building Services Consultants Ltd 54 Blossom Street York YO24 1AP

CLIENT YORK RACECOURSE

PROJECT YORK RACECOURSE SOUTHERN END MASTERPLAN

TITLE ELECTRICAL SERVICES BUSTARDTHORPE STAND

FIRE ALARM, PAVA AND SECURITY LAYOUT scale: 1:50 @ A0 date: JAN 2024 drawn: RG

CHECKED:

engineer: KH APPROVED:

H150 E 6702 C2