
ANNEX 1

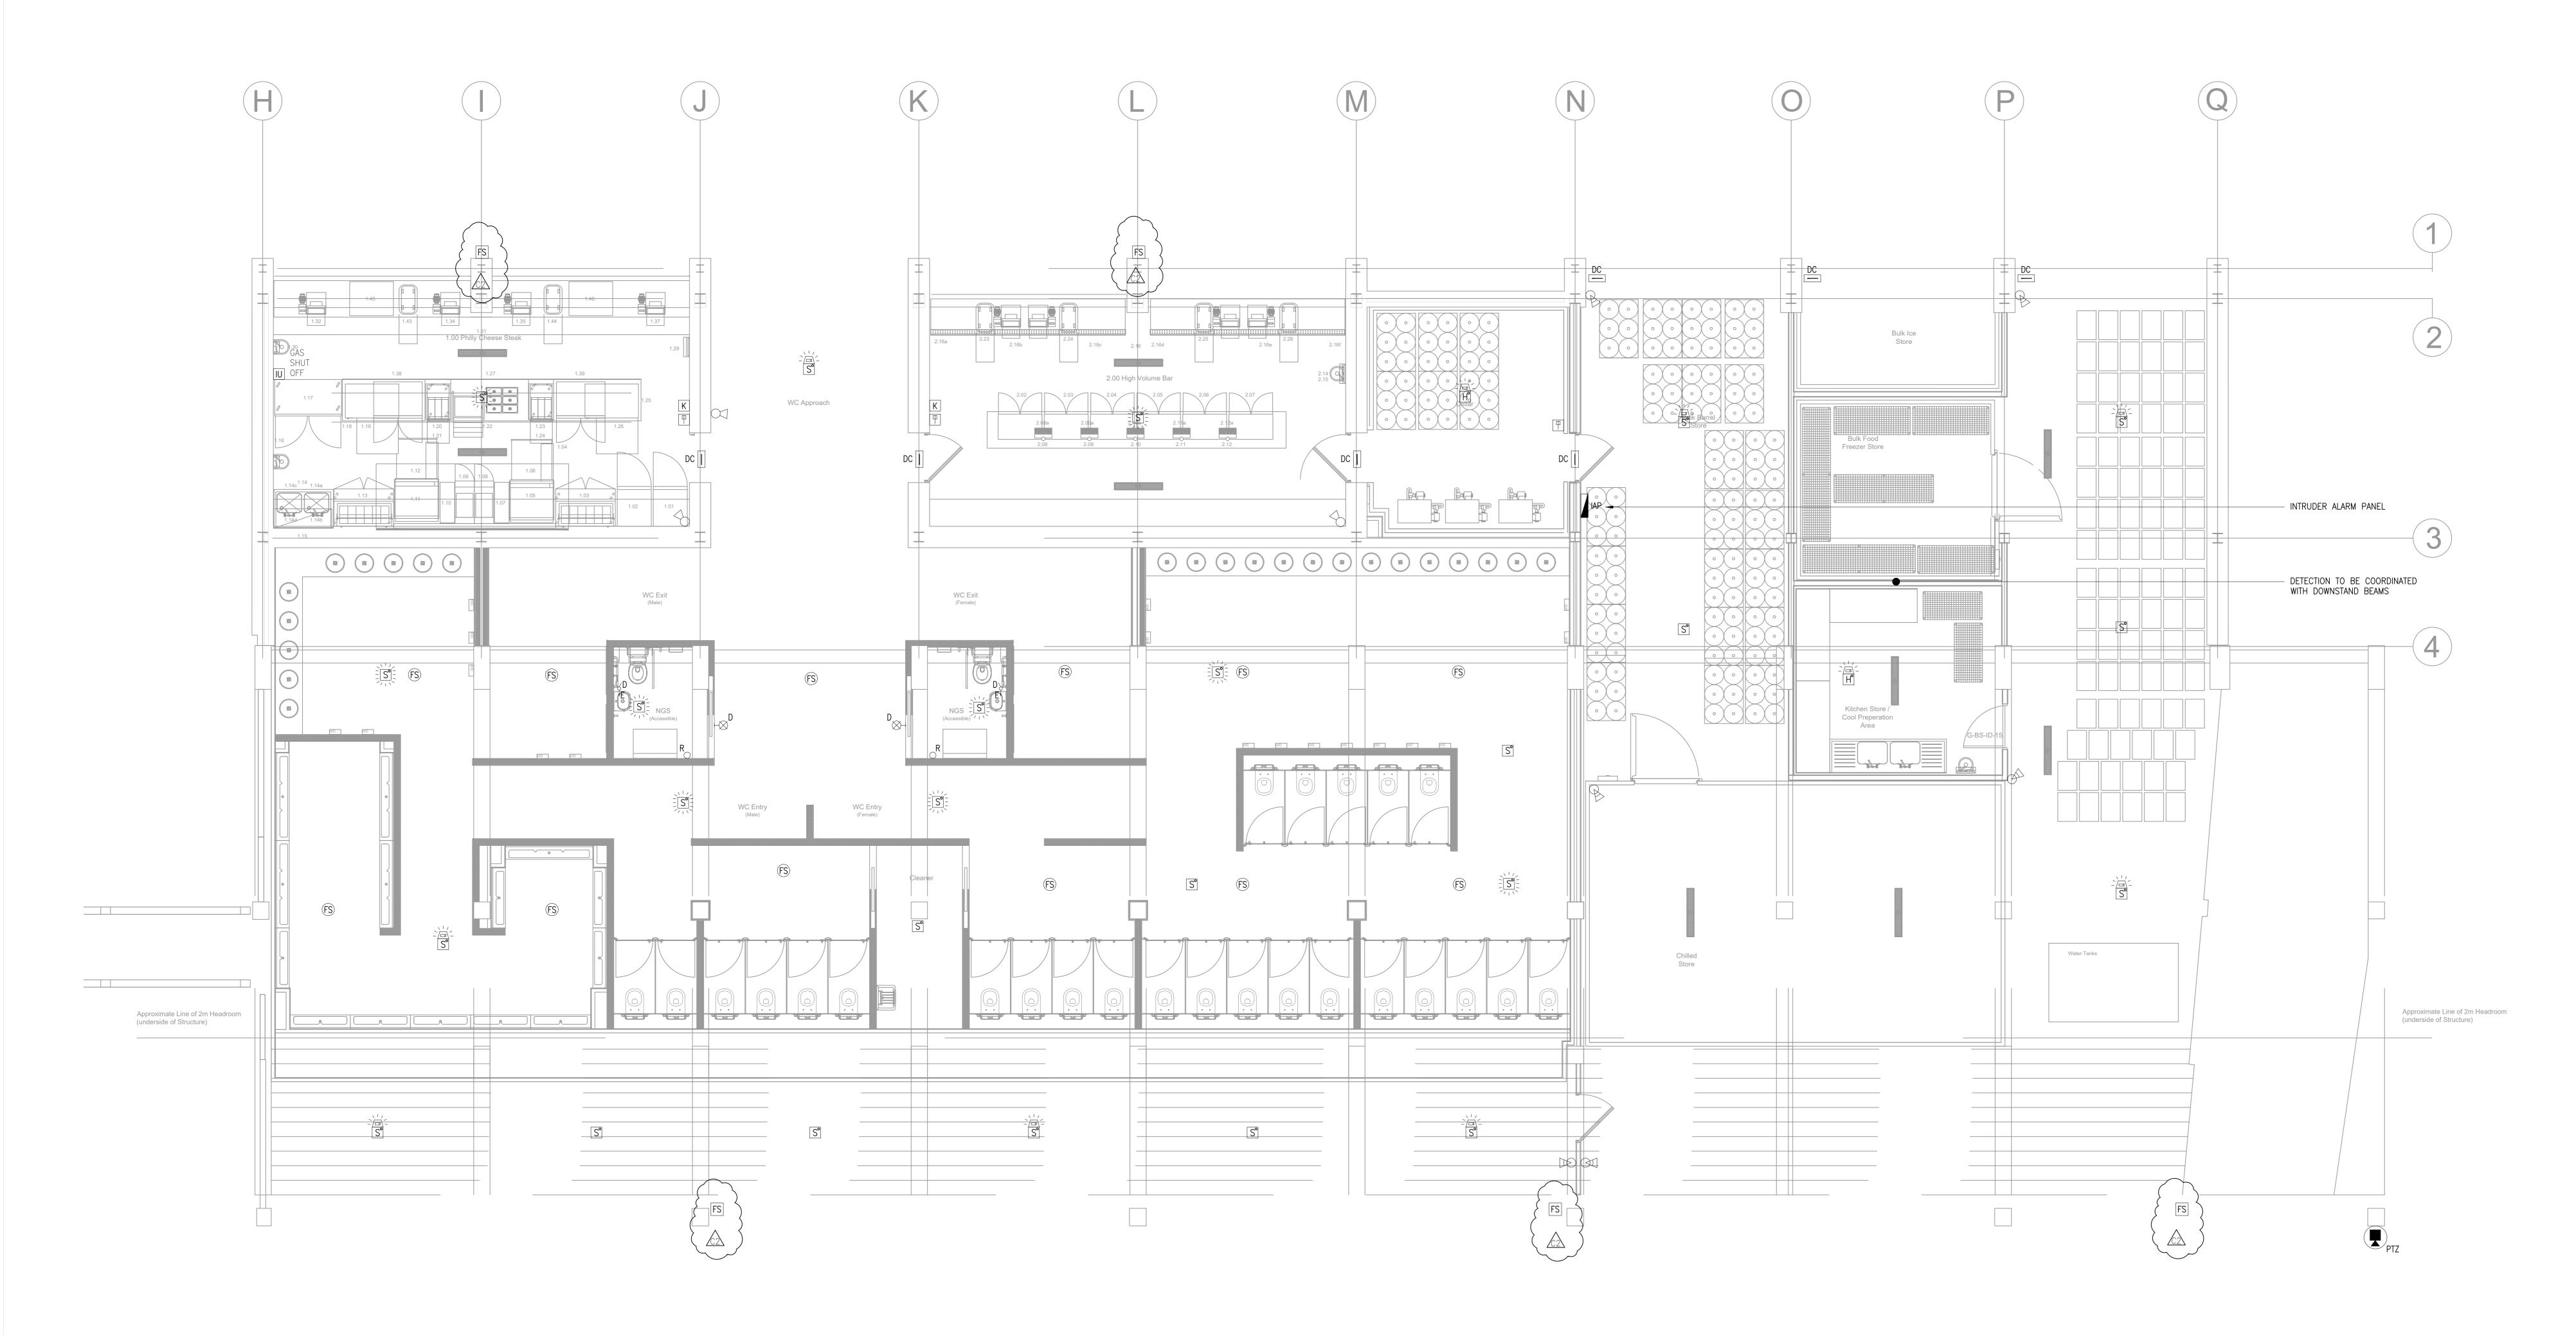

(C) HORIZON BUILDING SERVICES CONSULTANTS LTD

THIS DRAWING IS CONFIDENTIAL AND MAY NOT BE USED, COPIED OR DISCLOSED TO ANYONE WITHOUT PERMISSION OF HORIZON BUILDING SERVICES CONSULTANTS LTD

ALL DIMENSIONS IN MILLIMETRES UNLESS OTHERWISE

INSTALLATION AND TO BE CHECKED ON SITE PRIOR

NOTES:

1. THE DRAWINGS ARE TO BE READ IN CONJUNCTION WITH ALL OTHER ACCOMPANYING FHP DRAWINGS, SCHEDULES & SPECIFICATION DOCUMENTS

DO NOT SCALE FROM THIS DRAWING

3. THE DRAWINGS ARE NOT TO BE SCALED FROM.

4. ALL ROUTES ARE TO BE CHECKED ON SITE PRIOR 1 THE COMMENCEMENT OF WORKS.

5. ALL PIPEWORK, DUCTWORK, CONTAINMENT & PLANT TO BE INSTALLED IN ACCORDANCE WITH THE MANUFACTURER'S RECOMMENDATIONS AND GUIDELINE
 6. ALL SERVICES ROUTES ARE TO BE AGREED BETWEEN THE DESIGN TEAM AND CLIENT PRIOR TO

TO THE COMMENCEMENT OF WORKS.

<u>LEGEND</u> <u>FIRE ALARM</u>

FIRE ALARM CONTROL PANEL

[IU] FIRE ALARM INTERFACE UNIT

MANUAL CALL POINT

WALL MOUNTED SOUNDER

BEACON

S" SMOKE DETECTOR

S" SMOKE DETECTOR WITHIN CEILING VOID

SMOKE DETECTOR WITHIN ROOF VOID

SMOKE DETECTOR WITH

SMOKE DETECTOR WITH SOUNDER BASE/BEACON

SMOKE DETECTOR WITH FLASHING BEACON

HEAT DETECTOR WITH SOUNDER
BASE/BEACON

HEAT DETECTOR WITH FLASHING BEACON

CEILING MOUNTED FLASHING

<u>CCTV</u>

PTZ DOME CCTV CAMERA



INTRUDER ALARM

IAP INTRUDER ALARM PANEL

DC DOOR CONTACT

DUAL TECH DETECTOR

PIR DETECTOR

___ EXTERNAL SOUNDER

K KEYPAD

DISABLED WC ALARM

P REPEAT LAMP UNIT — WALL MOUNTED

D_E DISABLED ALARM PULL SWITCH

OR DISABLED ALARM RESET BUTTON

VOICE ANNUNCIATION (FIRE)

CEILING MOUNTED RECESSED FIRE DOME SPEAKER

FS WALL MOUNTED RECESSED FIRE DOME SPEAKER

C2 SPEAKERS ADDED TO SPECIALIST REQUIREMENTS

CONTRACT



C1 CONTRACT ISSUE



14.02.24 PT

12.01.24 PT



email. engineers@horizon.uk.net tel. 01904 672223 web. www.horizon.uk.net Horizon Building Services Consultants Ltd 54 Blossom Street York Y024 1AP

CLIENT YORK RACECOURSE

C1

PROJECT YORK RACECOURSE

SOUTHERN END MASTERPLAN

TITLE ELECTRICAL SERVICES
BUSTARDTHORPE STAND
FIRE ALARM, PAVA AND SECURITY LAYOUT

scale: 1:50 @ AO DATE: JAN 2024

drawn: RG engineer: KH

checked: approved:

H150 E 6703 C2